

ADDENDUM NO. 6
To the Contract Document and Project Specifications for the
Wayne High School Campus Improvements
Fort Wayne Community Schools (FWCS)
Fort Wayne, Indiana
November 18, 2025

To: All holders of the contract documents for the above project.

The items in this addendum are to become a part of the original documents as if included therein. The remainder of the original contract document is to remain in its entirety. This Addendum modifies the Contract Documents and Specifications as follows:


- Part 1 – General Clarifications
- Part 2 – Specifications
- Part 3 – Construction Drawings/Details
- Part 4 – Questions

PART 1 – GENERAL CLARIFICATIONS


PART 2 – SPECIFICATIONS (Replace - See Attached)

PART 3 – CONSTRUCTION DRAWING / DETAILS (Replace - See Attached)


1. Plan Sheet C1.6 –Site Demolition Plan – Zone D
Revised: Alternate #4 boundary

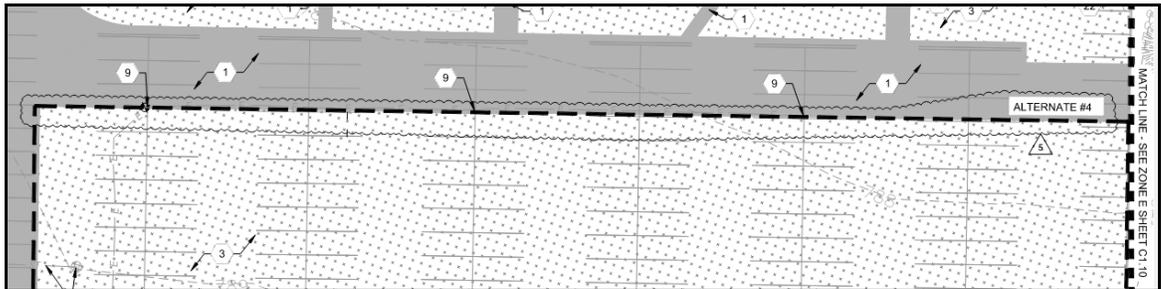

2. Plan Sheet C2.4 –Site Dimensional Plan – Zone D
Revised: Alternate #4 boundary

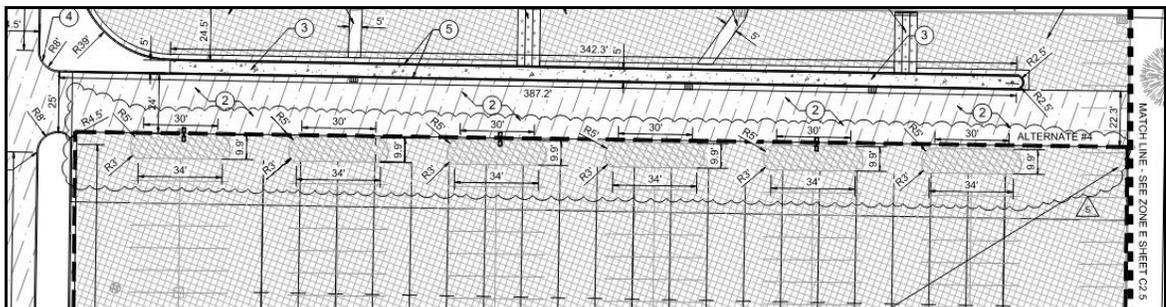


3. Plan Sheet C2.5 –Site Dimensional Plan – Zone E
ADD: Curb extension on the north side of drive entrance

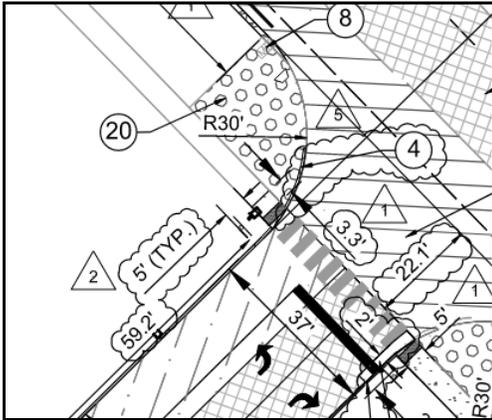


4. Plan Sheet L1.0 – Landscape Plan Overall
Revised: Evergreen Tree sizes to be “6’ H MIN.”

EVERGREEN TREES					
JV	JUNIPERUS VIRGINIANA	EASTERN RED CEDAR	6' H MIN.	6	B&B
PA	PICEA ABIES	NORWAY SPRUCE	6' H MIN.	3	B&B
ORNAMENTAL TREES					

5. Plan Sheet L1.3 – Site Landscapae Plan – Zone C
Revised: Alternate #1 boundary

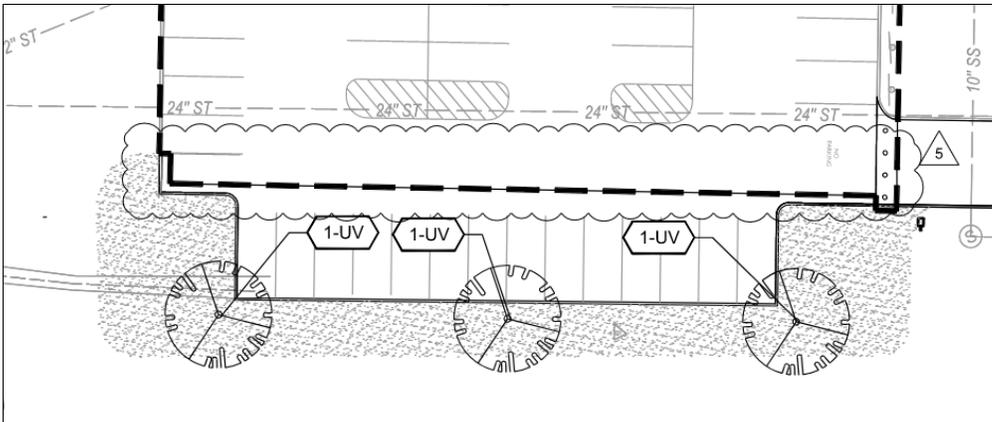


6. Plan Sheet L1.4 – Site Landscape Plan – Zone D
Revised: Grouping of trees to be “3-LR”

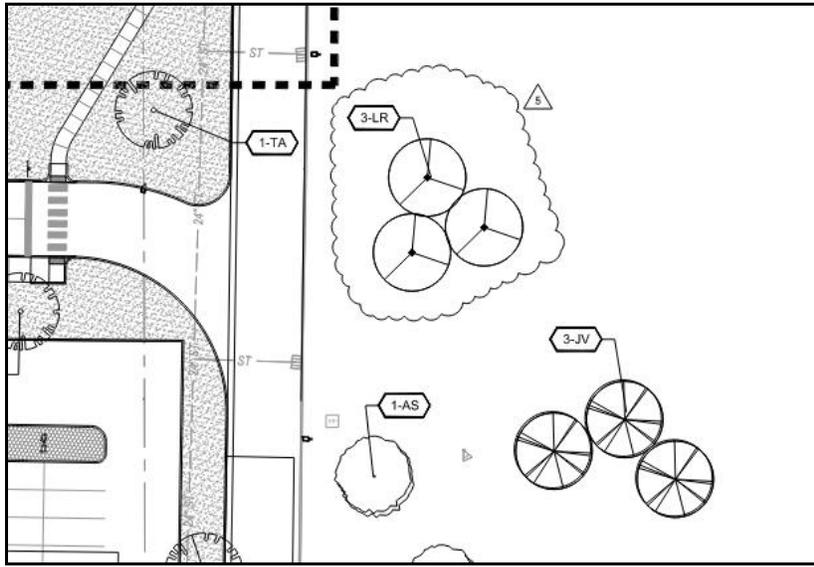

PART 4 – QUESTIONS


1. *Is the rock mulch shown under the detention basin buffer fence to be included in the base bid.*
 1. Yes, the rock mulch under the detention basin buffer fence is to be included in the project base bid.

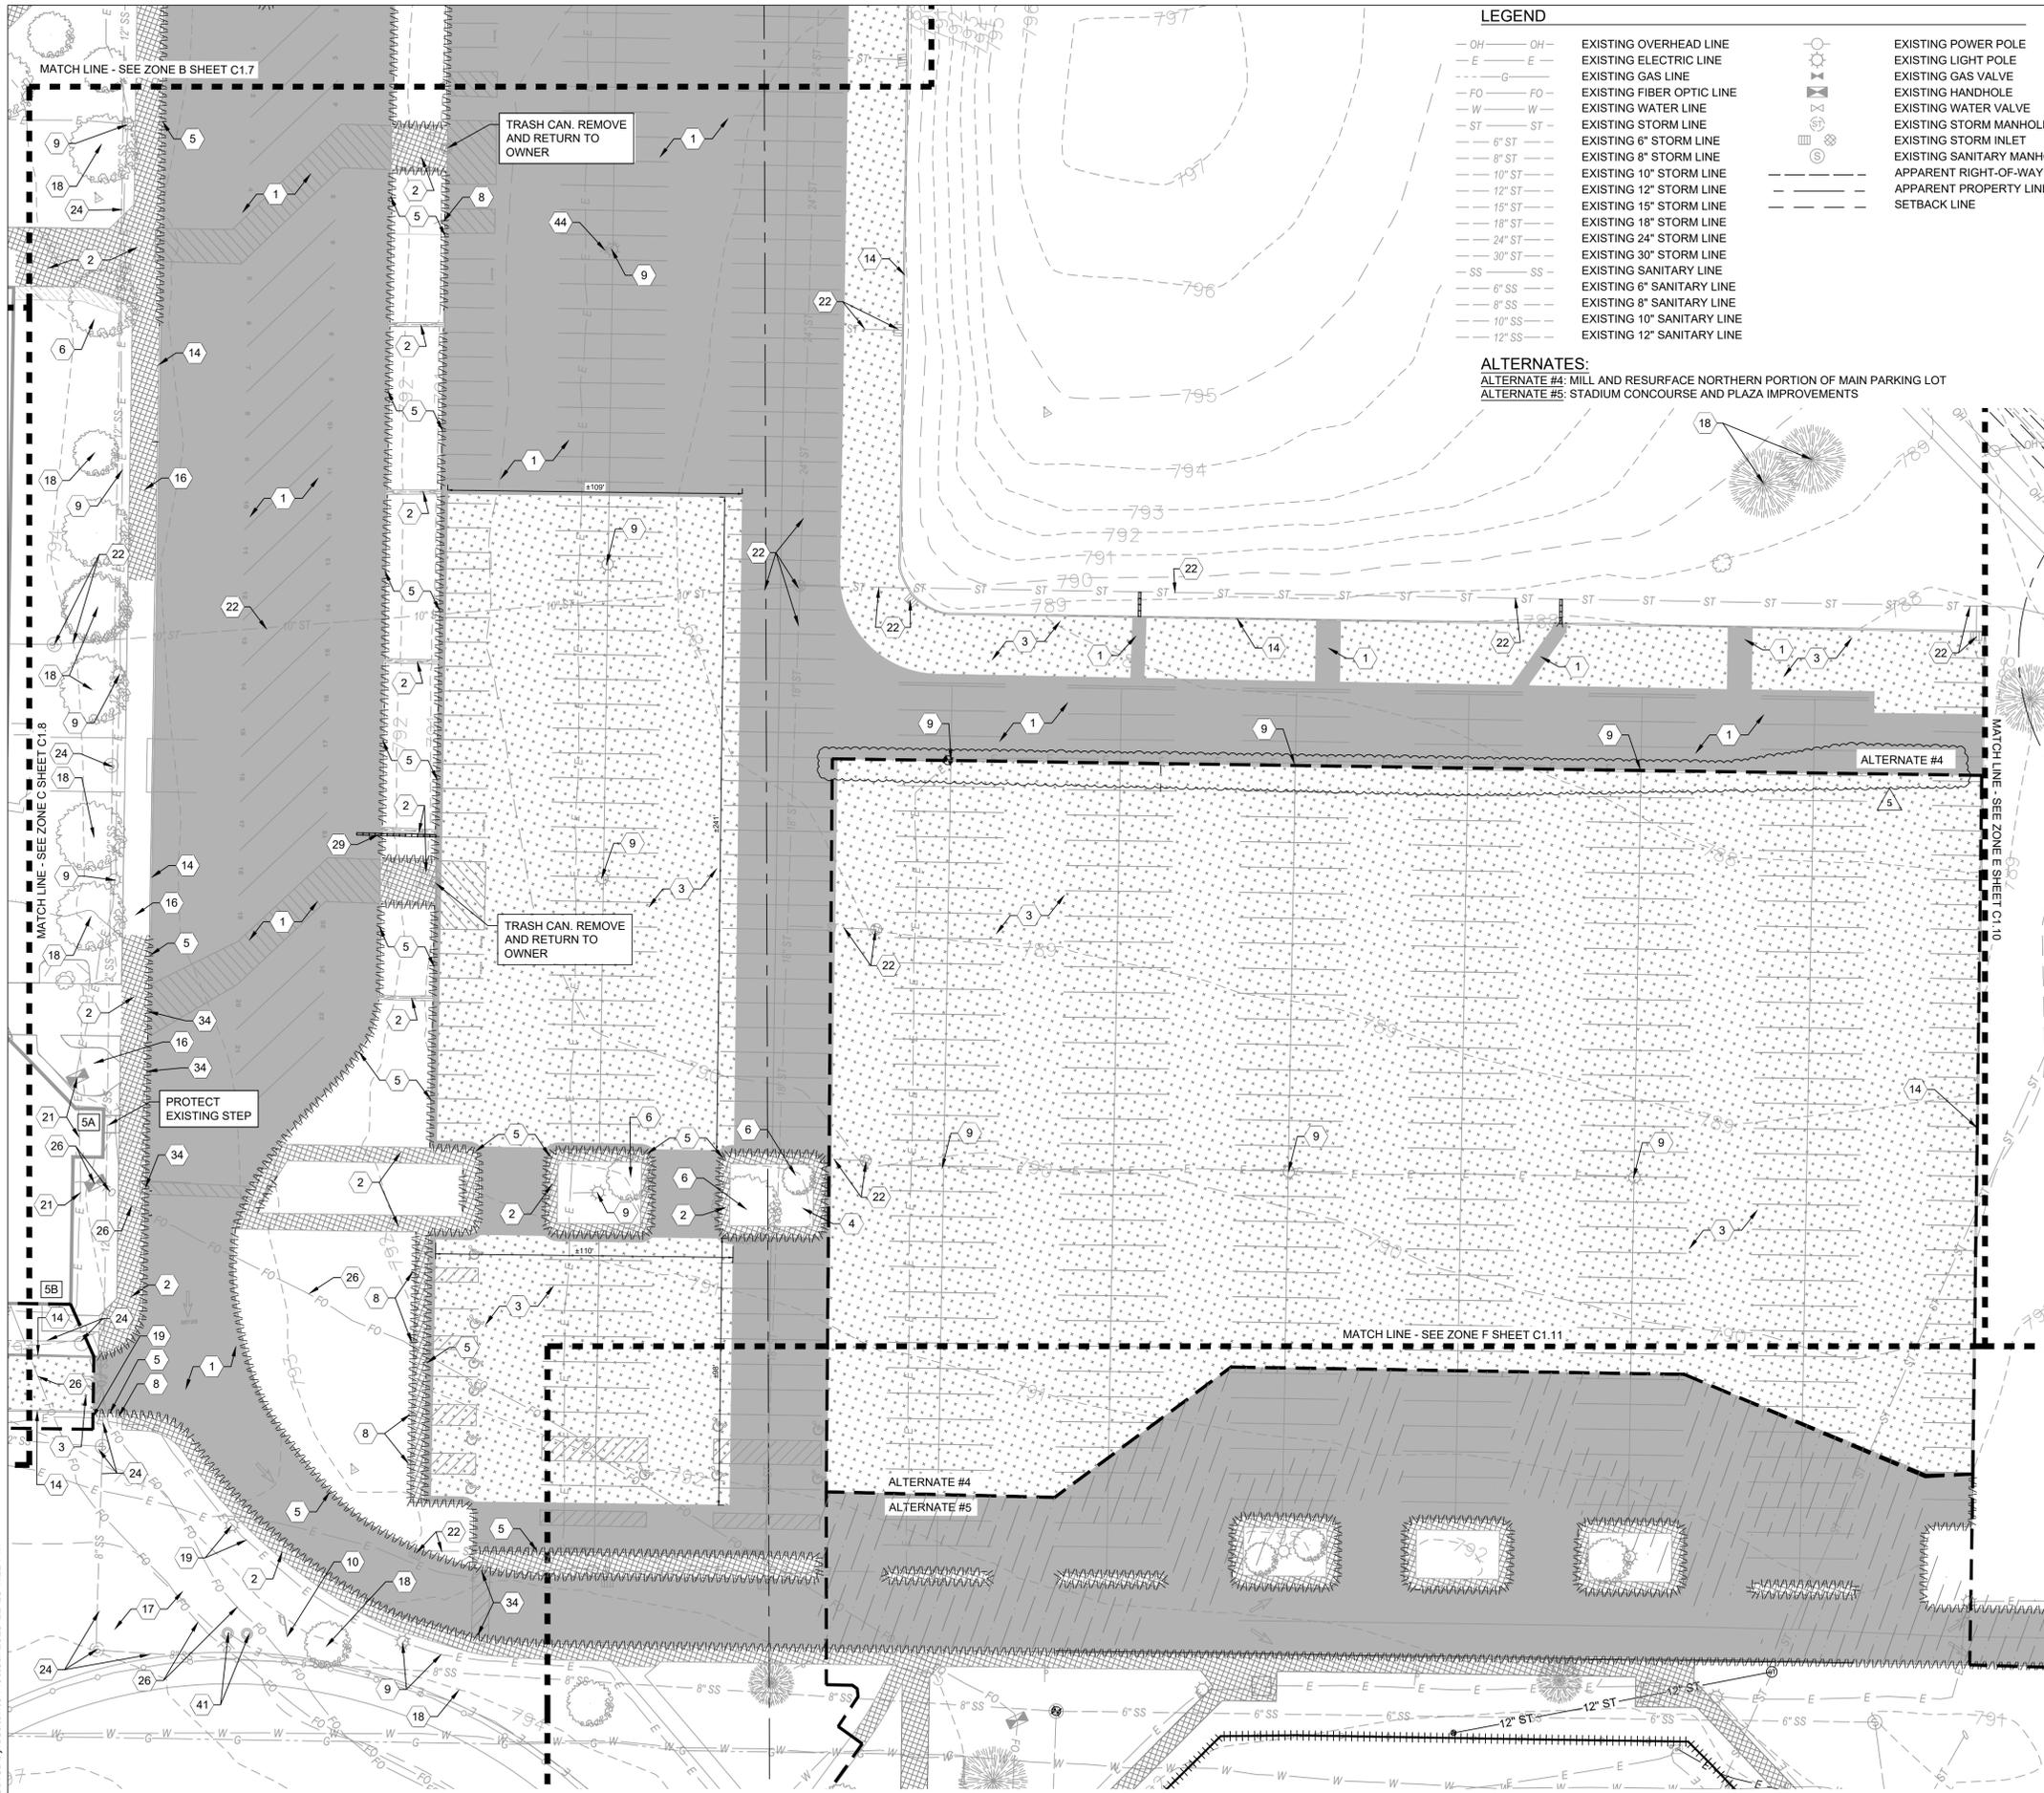


LEGEND

— OH — OH	EXISTING OVERHEAD LINE		EXISTING POWER POLE
— E — E	EXISTING ELECTRIC LINE		EXISTING LIGHT POLE
— G — G	EXISTING GAS LINE		EXISTING GAS VALVE
— FO — FO	EXISTING FIBER OPTIC LINE		EXISTING HANDHOLE
— W — W	EXISTING WATER LINE		EXISTING WATER VALVE
— ST — ST	EXISTING STORM LINE		EXISTING STORM MANHOLE
— 6" ST —	EXISTING 6" STORM LINE		EXISTING SANITARY INLET
— 8" ST —	EXISTING 8" STORM LINE		EXISTING SANITARY MANHOLE
— 10" ST —	EXISTING 10" STORM LINE		APPARENT RIGHT-OF-WAY LINE
— 12" ST —	EXISTING 12" STORM LINE		SETBACK LINE
— 15" ST —	EXISTING 15" STORM LINE		
— 18" ST —	EXISTING 18" STORM LINE		
— 24" ST —	EXISTING 24" STORM LINE		
— 30" ST —	EXISTING 30" STORM LINE		
— SS — SS	EXISTING SANITARY LINE		
— 6" SS —	EXISTING 6" SANITARY LINE		
— 8" SS —	EXISTING 8" SANITARY LINE		
— 10" SS —	EXISTING 10" SANITARY LINE		
— 12" SS —	EXISTING 12" SANITARY LINE		

ALTERNATES:
 ALTERNATE #4: MILL AND RESURFACE NORTHERN PORTION OF MAIN PARKING LOT
 ALTERNATE #5: STADIUM CONCOURSE AND PLAZA IMPROVEMENTS

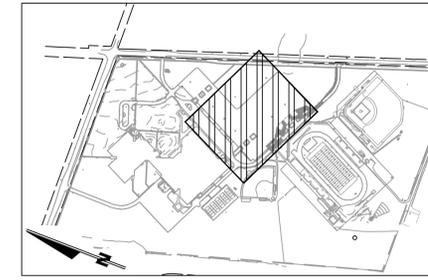



- DEMOLITION NOTES:**
- 1 REMOVE FULL DEPTH ASPHALT PAVEMENT AND CONCRETE SUBBASE MATERIAL. REMOVE AGGREGATE SUBBASE AS REQUIRED TO MEET PROPOSED FINISHED GRADE. NEAT LINE SAWCUT AT REMOVAL LIMITS.
 - 2 REMOVE EXISTING CONCRETE PAVEMENT FULL DEPTH. REMOVE AGGREGATE SUBBASE AS REQUIRED TO MEET PROPOSED FINISHED GRADE. NEAT LINE SAWCUT AT REMOVAL LIMITS.
 - 3 MILL AND RESURFACE ASPHALT - 2" DEPTH
 - 4 NOT USED
 - 5 REMOVE EXISTING CONCRETE CURB. NEAT LINE SAWCUT AT REMOVAL LIMITS
 - 6 REMOVE EXISTING TREE AND STUMP AND ROOT BALL
 - 7 REMOVE EXISTING SIGNAGE, POST, AND ASSOCIATED FOUNDATIONS
 - 8 SALVAGE AND RELOCATE SIGNAGE. SEE SIGNAGE AND PAVEMENT MARKING PLAN FOR NEW LOCATION.
 - 9 REFER TO LIGHTING PLAN FOR LIGHT POLE, FOUNDATION AND ASSOCIATED CONDUIT INFORMATION
 - 10 PROTECT EXISTING FLAG POLE
 - 11 PROTECT EXISTING BENCH
 - 12 PROTECT EXISTING FENCE
 - 13 PROTECT ALL EXISTING BUILDINGS, WALLS, FOUNDATIONS, CANOPIES, AND FACADES
 - 14 PROTECT EXISTING CURB
 - 15 PROTECT EXISTING ASPHALT PAVEMENT AND PAVEMENT MARKINGS
 - 16 PROTECT EXISTING CONCRETE PAVEMENT
 - 17 PROTECT EXISTING VEGETATION
 - 18 PROTECT EXISTING TREE AND ROOTS
 - 19 PROTECT EXISTING LIGHT POLE AND ASSOCIATED UNDERGROUND ELECTRIC LINES
 - 20 PROTECT EXISTING SIGN AND FOUNDATION
 - 21 PROTECT EXISTING UNDERGROUND ELECTRIC LINE AND ASSOCIATED STRUCTURES
 - 22 PROTECT EXISTING STORM LINE AND ASSOCIATED STRUCTURES. ADJUST RIM ELEVATION AS REQUIRED TO FINISHED GRADE
 - 23 PROTECT EXISTING GAS LINE AND ASSOCIATED STRUCTURES
 - 24 PROTECT EXISTING SANITARY LINE AND ASSOCIATED STRUCTURES. ADJUST RIM ELEVATION AS REQUIRED TO FINISHED GRADE
 - 25 PROTECT EXISTING WATER LINE AND ASSOCIATED STRUCTURES
 - 26 PROTECT EXISTING COMMUNICATIONS LINE AND STRUCTURE
 - 27 PROTECT EXISTING LONG JUMP TRACK
 - 28 REMOVE EXISTING FENCE AND AGGREGATE FULL DEPTH
 - 29 REMOVE EXISTING SEWER PIPING
 - 30 PROTECT EXISTING UTILITY POLE AND ASSOCIATED OVERHEAD LINES, GUY WIRES AND STRUCTURES
 - 31 REMOVE EXISTING TICKET BOOTH. DISCONNECT POWER SOURCE TO TICKET BOOTH. MAINTAIN EXISTING CIRCUITS FOR EXTENSION TO NEW TICKET BOOTH
 - 32 REMOVE EXISTING PIPE BOLLARD AND FOUNDATION
 - 33 PROTECT EXISTING PIPE BOLLARD AND FOUNDATION
 - 34 REMOVE EXISTING CURB RAMP
 - 35 PROTECT EXISTING CURB RAMP
 - 36 PROTECT EXISTING BLEACHERS
 - 37 PROTECT EXISTING TRACK
 - 38 PROTECT EXISTING FIELD EVENT
 - 39 PROTECT EXISTING CANOPY COLUMNS
 - 40 RELOCATE MAILBOX
 - 41 PROTECT SCORE BOARD AND FOUNDATION
 - 42 REMOVE FULL DEPTH AGGREGATE
 - 43 PROTECT SERVICE DRIVE
 - 44 SALVAGE SIGN AND RETURN TO OWNER
 - 45 PROTECT EXISTING RETAINING WALL AND FOUNDATION
 - 46 REMOVE EXISTING HAND RAILING
 - 47 RELOCATE MEMORIAL PANEL AND SIGNAGE

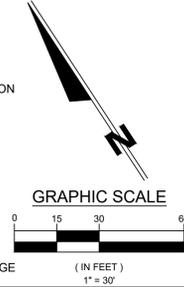

<p>WAYNE HIGH SCHOOL CAMPUS IMPROVEMENTS FORT WAYNE COMMUNITY SCHOOLS 1200 S CLINTON STREET SITE DEMOLITION PLAN - ZONE D</p>	<table border="1" style="width: 100%; border-collapse: collapse;"> <tr> <td style="width: 50%;">DESIGNED BY: JPR TEAM</td> <td style="width: 50%;">DATE: NOVEMBER 7, 2025</td> </tr> <tr> <td>REVIEWED BY: CEE, AC</td> <td>JOB NUMBER: 2025-01487</td> </tr> <tr> <td>DRAWN BY: JPR TEAM</td> <td>HORIZ. SCALE: 1" = 30'</td> </tr> <tr> <td>REVIEWED BY: CEE, AC</td> <td>VERTICAL SCALE: N/A</td> </tr> </table>	DESIGNED BY: JPR TEAM	DATE: NOVEMBER 7, 2025	REVIEWED BY: CEE, AC	JOB NUMBER: 2025-01487	DRAWN BY: JPR TEAM	HORIZ. SCALE: 1" = 30'	REVIEWED BY: CEE, AC	VERTICAL SCALE: N/A
DESIGNED BY: JPR TEAM	DATE: NOVEMBER 7, 2025								
REVIEWED BY: CEE, AC	JOB NUMBER: 2025-01487								
DRAWN BY: JPR TEAM	HORIZ. SCALE: 1" = 30'								
REVIEWED BY: CEE, AC	VERTICAL SCALE: N/A								

C1.9


File: J:\Projects\2025\Projects\2025-01487 Wayne High School\07_Design\ENG\Plans\C201_DIMENSIONAL PLAN - OVERALL.dwg
 Saved By: ramos Plotted: 2025-11-18 5:16 PM

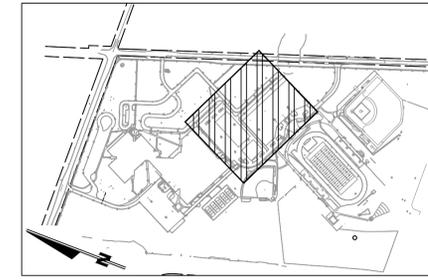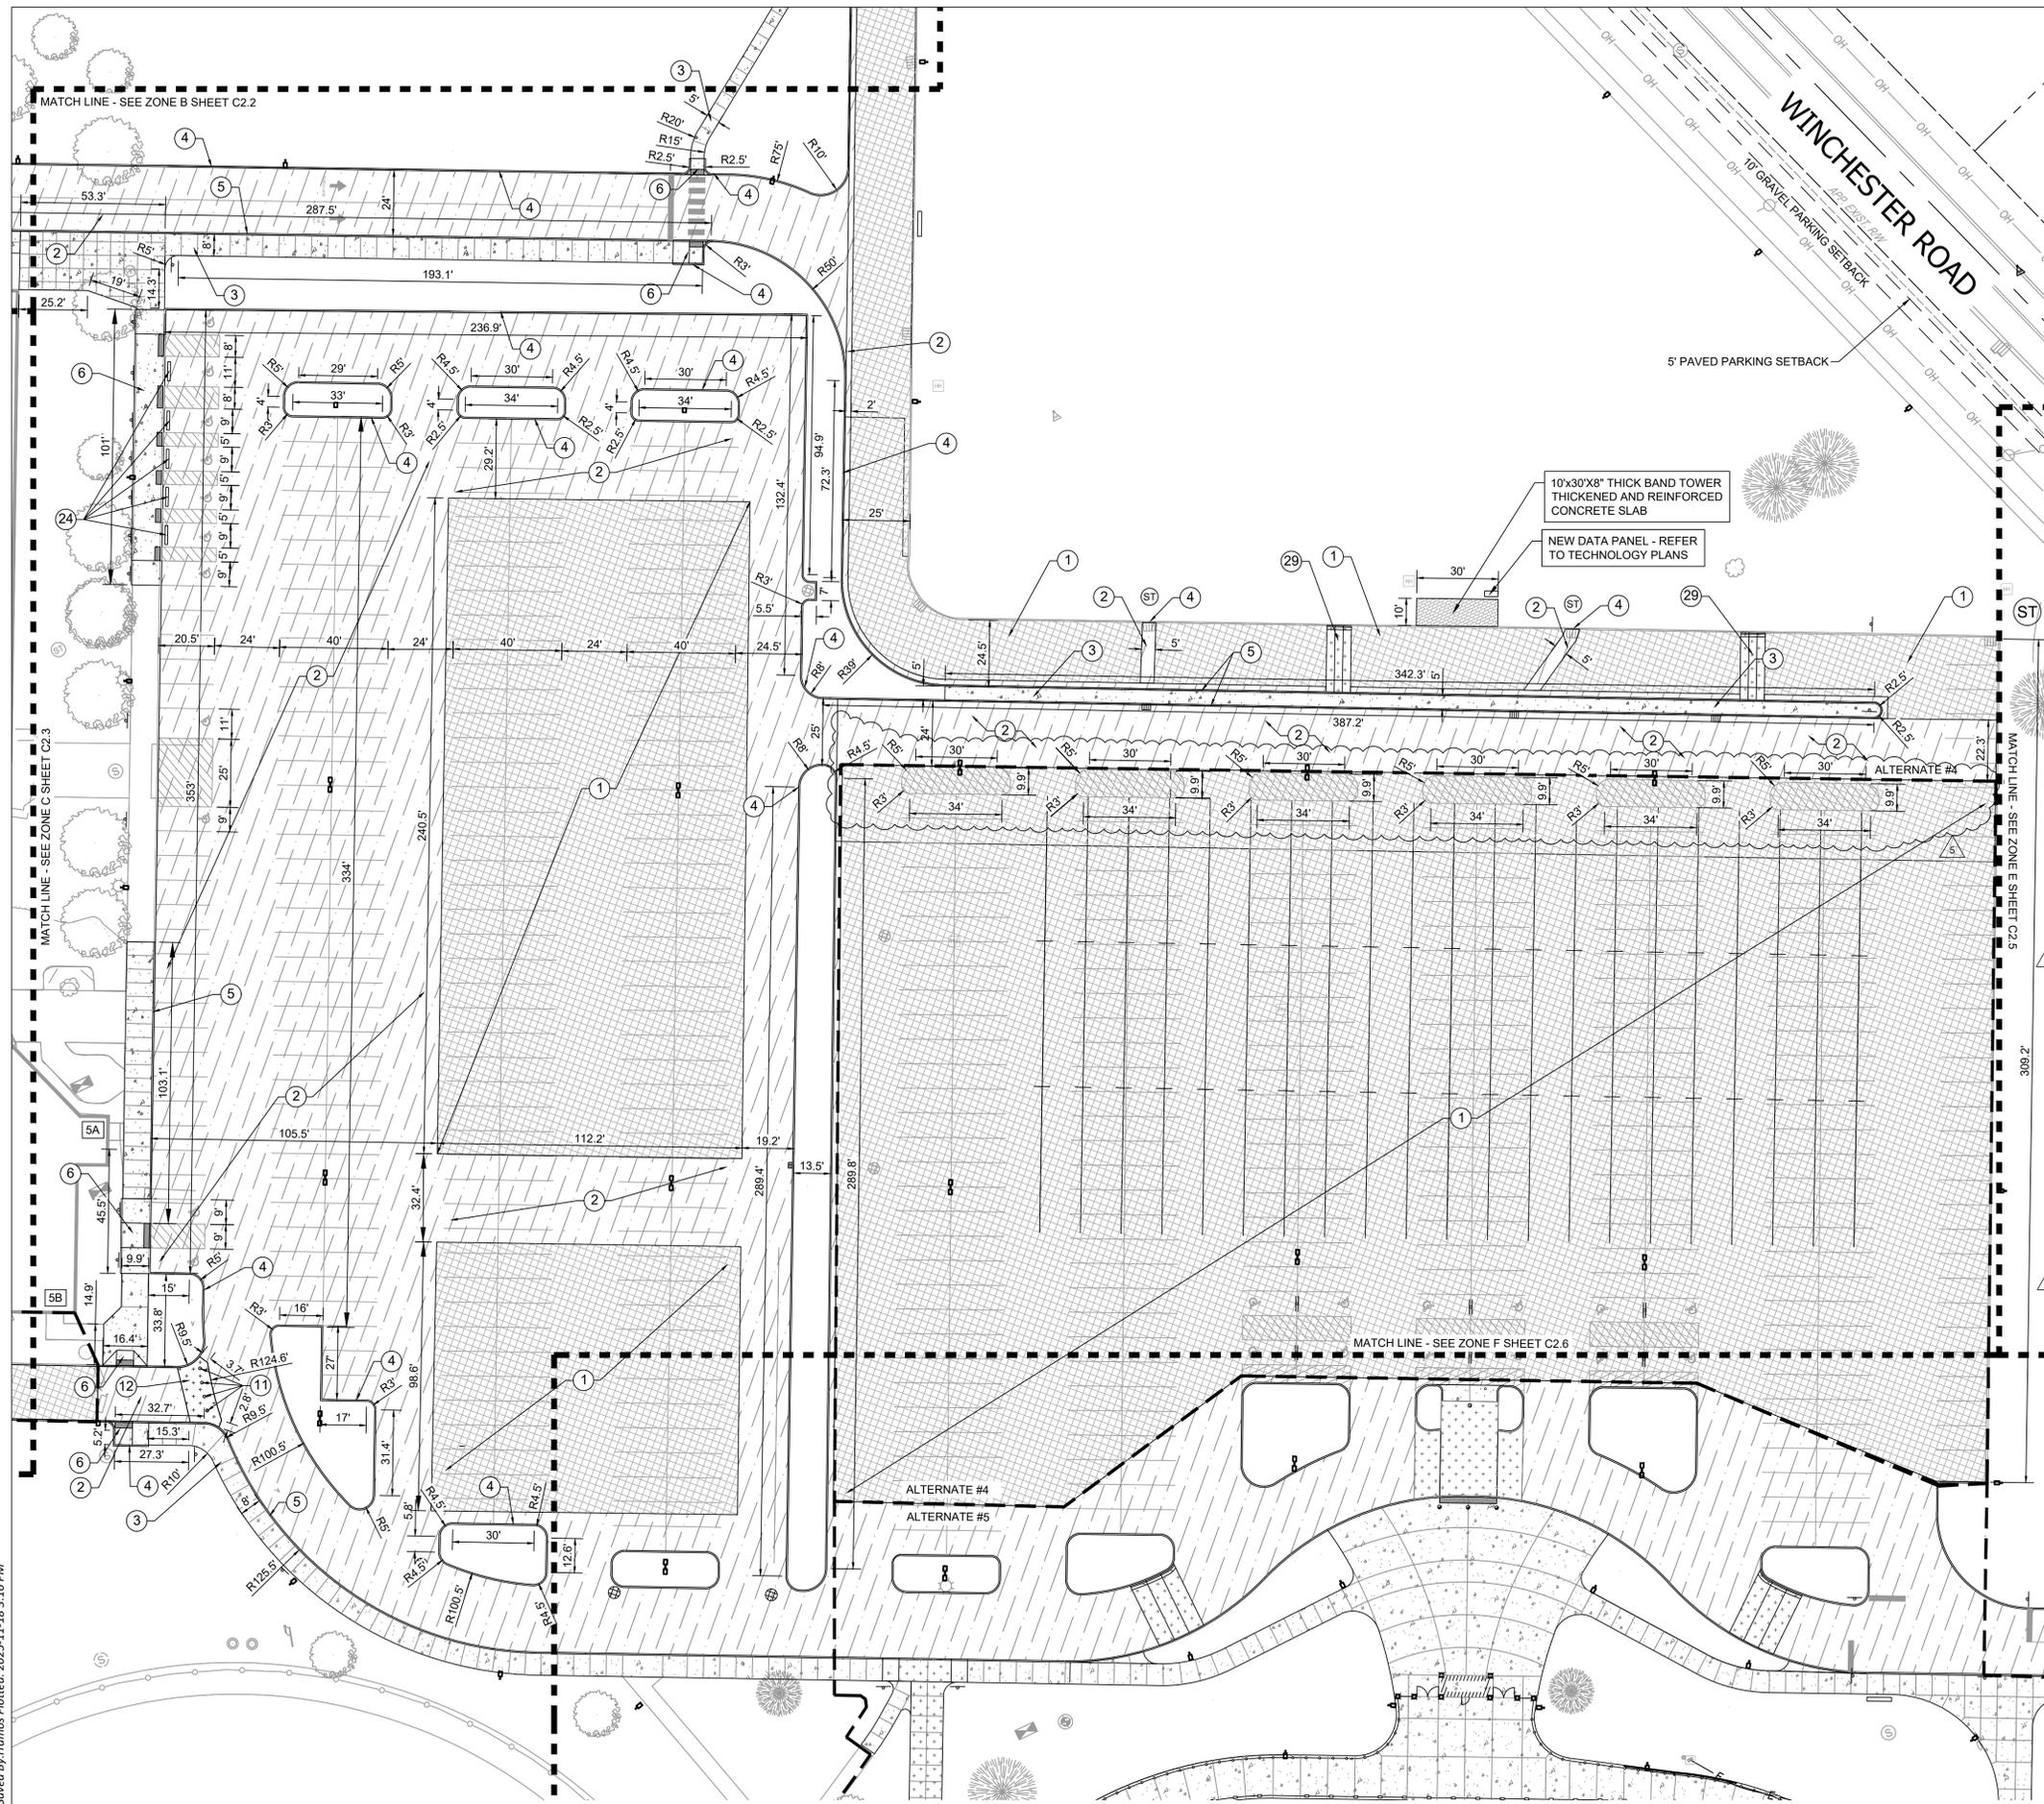

DETAILS LEGEND:



1	MILL & RESURFACE ASPHALT PAVEMENT	DETAIL 4 / C8.1
2	ASPHALT PARKING LOT PAVEMENT - FULL DEPTH REPLACEMENT	DETAIL 1 OR 2 / C8.1
3	4" CONCRETE	DETAIL 5 / C8.1
4	STANDARD CONCRETE CURB	DETAIL 7 / C8.1
5	INTEGRAL CONCRETE CURB	DETAIL 8 / C8.1
6	CURB RAMP	REFER TO SHEET C3.8
7	PERIMETER CHAIN LINK FENCE	DETAIL 11 / C8.1
8	MAILBOX ASSEMBLY	DETAIL 5 / C8.4
9	FENCE GATE	DETAIL 12 / C8.1 (SINGLE GATE) DETAIL 13 / C8.1 (DOUBLE GATE)
10	LIGHT POLE	REFER TO LIGHTING PLAN
11	REMOVABLE BOLLARDS	DETAIL 10 / C8.1
12	8" CONCRETE	DETAIL 6 / C8.1
13	8" BLACK VINYL COATED CHAIN LINK FENCE	DETAIL 11 / C8.1
14	4" BLACK VINYL COATED CHAIN LINK FENCE	DETAIL 11 / C8.1
15	NEW TICKET BOOTH	REFER TO ARCHITECTURAL PLAN
16	NEW MAINTENANCE BUILDING	BY OTHERS
17	RIGHT OF WAY ASPHALT PAVEMENT	DETAIL 3 / C8.1
18	HEAVY DUTY ASPHALT PAVEMENT	DETAIL 2 / C8.1
19	8" ORNAMENTAL FENCE	DETAIL 6 / C8.3
20	EROSION CONTROL SURFACE FLEXAMAT OR APPROVED EQUAL	DETAIL 3 / C5.3
21	ORNAMENTAL FENCE GATE	REFER TO ARCHITECTURAL PLAN
22	MONUMENT COLUMN	REFER TO ARCHITECTURAL PLAN
23	STANDARD ROLLED CURB	DETAIL 3 / C8.5
24	CONCRETE WHEEL STOP	DETAIL 7 / C8.3
25	AGGREGATE	DETAIL 4 / C8.3
26	EMERGENCY SPILLWAY	DETAIL 9 / C8.2
27	RETAINING WALL	DETAIL 3 / C8.2
28	RAMP HANDRAIL	DETAIL 5 / C8.3
29	SPEED TABLE	DETAIL 5 OR 6 / C8.5
30	BUS PARKING LOT GATE	DETAIL 14 / C8.1
31	EROSION CONTROL TURF REINFORCEMENT	DETAIL 7 / C5.2
32	TRAFFIC BARRIER	DETAIL 27 / C8.6

ALTERNATES:
 ALTERNATE #4: MILL AND RESURFACE NORTHERN PORTION OF MAIN PARKING LOT
 ALTERNATE #5: STADIUM CONCOURSE AND PLAZA IMPROVEMENTS

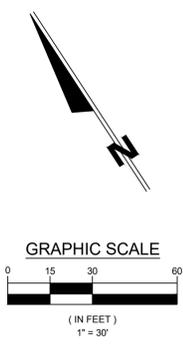

JONES P E T R I E R A F A N S K I P E T R I E P R A F A N S K I P 317.646.9405 F 317.646.2201		REVISION 4 FOR APPENDIX 6 REVISION 1 FOR APPENDIX 1 REV JJB 11-18-2025 RRM 11-07-2025 BY DATE
REGISTERED PROFESSIONAL ENGINEER No. 12000703 STATE OF INDIANA 10-16-23		
WAYNE HIGH SCHOOL CAMPUS IMPROVEMENTS FORT WAYNE COMMUNITY SCHOOLS 1200 S CLINTON STREET FORT WAYNE, INDIANA SITE DIMENSIONAL PLAN - ZONE D		
DESIGNED BY: JPR TEAM REVIEWED BY: CEE, AC DRAWN BY: JPR TEAM REVIEWED BY: CEE, AC		DATE: NOVEMBER 7, 2025 JOB NUMBER: 2025-01487 HORIZ. SCALE: 1" = 30' VERTICAL SCALE: N/A
C2.4		

File: J:\Projects\2025\Projects\2025-01487 Wayne High School\07_Design\ENG\Plans\C201_DIMENSIONAL PLAN - OVERALL.dwg
 Saved By: jankley Printed: 2025-11-18 3:28 PM

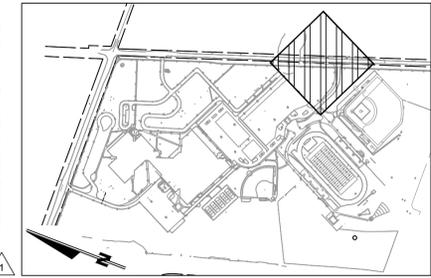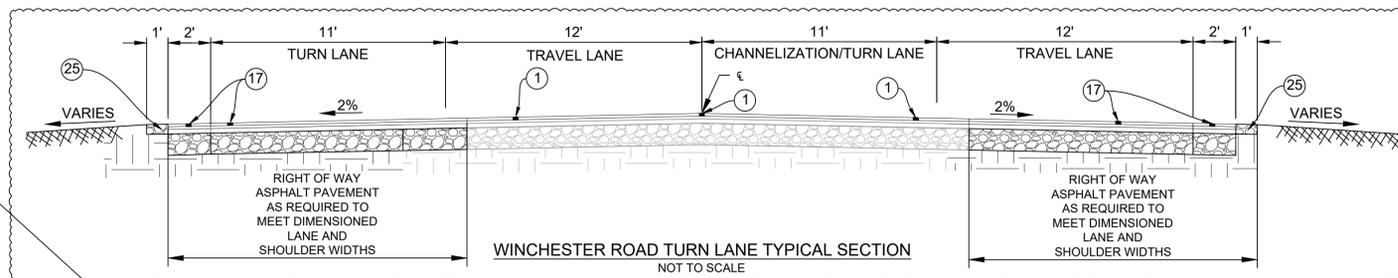


CONTRACTOR SHALL COORDINATE WITH PRIVATE DRIVE OWNERS TO PROVIDE ACCESS AT ALL TIMES

CONTRACTOR TO COORDINATE WITH UTILITY PROVIDER AND BE RESPONSIBLE FOR RELOCATION WORK OF COMMUNICATION PEDESTAL

CONTRACTOR TO COORDINATE WITH UTILITY PROVIDER AND BE RESPONSIBLE FOR RELOCATION WORK OF UTILITY POLE AND COMMUNICATION PEDESTAL


DETAILS LEGEND:

1	MILL & RESURFACE ASPHALT PAVEMENT	DETAIL 4 / C8.1
2	ASPHALT PARKING LOT PAVEMENT - FULL DEPTH REPLACEMENT	DETAIL 1 OR 2 / C8.1
3	4" CONCRETE	DETAIL 5 / C8.1
4	STANDARD CONCRETE CURB	DETAIL 7 / C8.1
5	INTEGRAL CONCRETE CURB	DETAIL 8 / C8.1
6	CURB RAMP	REFER TO SHEET C3.8
7	PERIMETER CHAIN LINK FENCE	DETAIL 11 / C8.1
8	MAILBOX ASSEMBLY	DETAIL 5 / C8.4
9	FENCE GATE	DETAIL 12 / C8.1 (SINGLE GATE) DETAIL 13 / C8.1 (DOUBLE GATE)
10	LIGHT POLE	REFER TO LIGHTING PLAN
11	REMOVABLE BOLLARDS	DETAIL 10 / C8.1
12	8" CONCRETE	DETAIL 6 / C8.1
13	8" BLACK VINYL COATED CHAIN LINK FENCE	DETAIL 11 / C8.1
14	4" BLACK VINYL COATED CHAIN LINK FENCE	DETAIL 11 / C8.1
15	NEW TICKET BOOTH	REFER TO ARCHITECTURAL PLAN
16	NEW MAINTENANCE BUILDING	BY OTHERS
17	RIGHT OF WAY ASPHALT PAVEMENT	DETAIL 3 / C8.1
18	HEAVY DUTY ASPHALT PAVEMENT	DETAIL 2 / C8.1
19	8" ORNAMENTAL FENCE	DETAIL 6 / C8.3
20	EROSION CONTROL SURFACE FLEXAMAT OR APPROVED EQUAL	DETAIL 3 / C5.3
21	ORNAMENTAL FENCE GATE	REFER TO ARCHITECTURAL PLAN
22	MONUMENT COLUMN	REFER TO ARCHITECTURAL PLAN
23	STANDARD ROLLED CURB	DETAIL 3 / C8.5
24	CONCRETE WHEEL STOP	DETAIL 7 / C8.3
25	AGGREGATE	DETAIL 4 / C8.3
26	EMERGENCY SPILLWAY	DETAIL 9 / C8.2
27	RETAINING WALL	DETAIL 3 / C8.2
28	RAMP HANDRAIL	DETAIL 5 / C8.3
29	SPEED TABLE	DETAIL 5 OR 6 / C8.5
30	BUS PARKING LOT GATE	DETAIL 14 / C8.1
31	EROSION CONTROL TURF REINFORCEMENT	DETAIL 7 / C5.2
32	TRAFFIC BARRIER	DETAIL 27 / C8.6

 

JOB	11-16-2025
REVISION 4 FOR ADDENDUM 6	
REVISION 2 FOR ADDENDUM 3	
REVISION 1 FOR ADDENDUM 1	
REV	DESCRIPTION
BY	DATE

JONES PETERA PRAFINSKI
 PE #16456 IN
 P 317.846.9045 F 317.844.2971

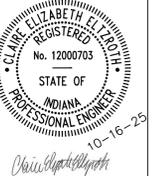


WAYNE HIGH SCHOOL CAMPUS IMPROVEMENTS
FORT WAYNE COMMUNITY SCHOOLS
 1200 S CLINTON STREET
SITE DIMENSIONAL PLAN - ZONE E

DESIGNED BY: JPR TEAM
 REVIEWED BY: CEE, AC
 DRAWN BY: JPR TEAM
 REVIEWED BY: CEE, AC

DATE: NOVEMBER 7, 2025
 JOB NUMBER: 2025-01487
 HORIZ. SCALE: 1" = 30'
 VERTICAL SCALE: N/A

C2.5

File: J:\Projects\2025-01487 Wayne High School\07_Design\IMEG\Plans\1001_LANDSCAPE PLAN - OVERALL.dwg
Saved By: jankley Plotted: 2025-11-18 10:09 AM

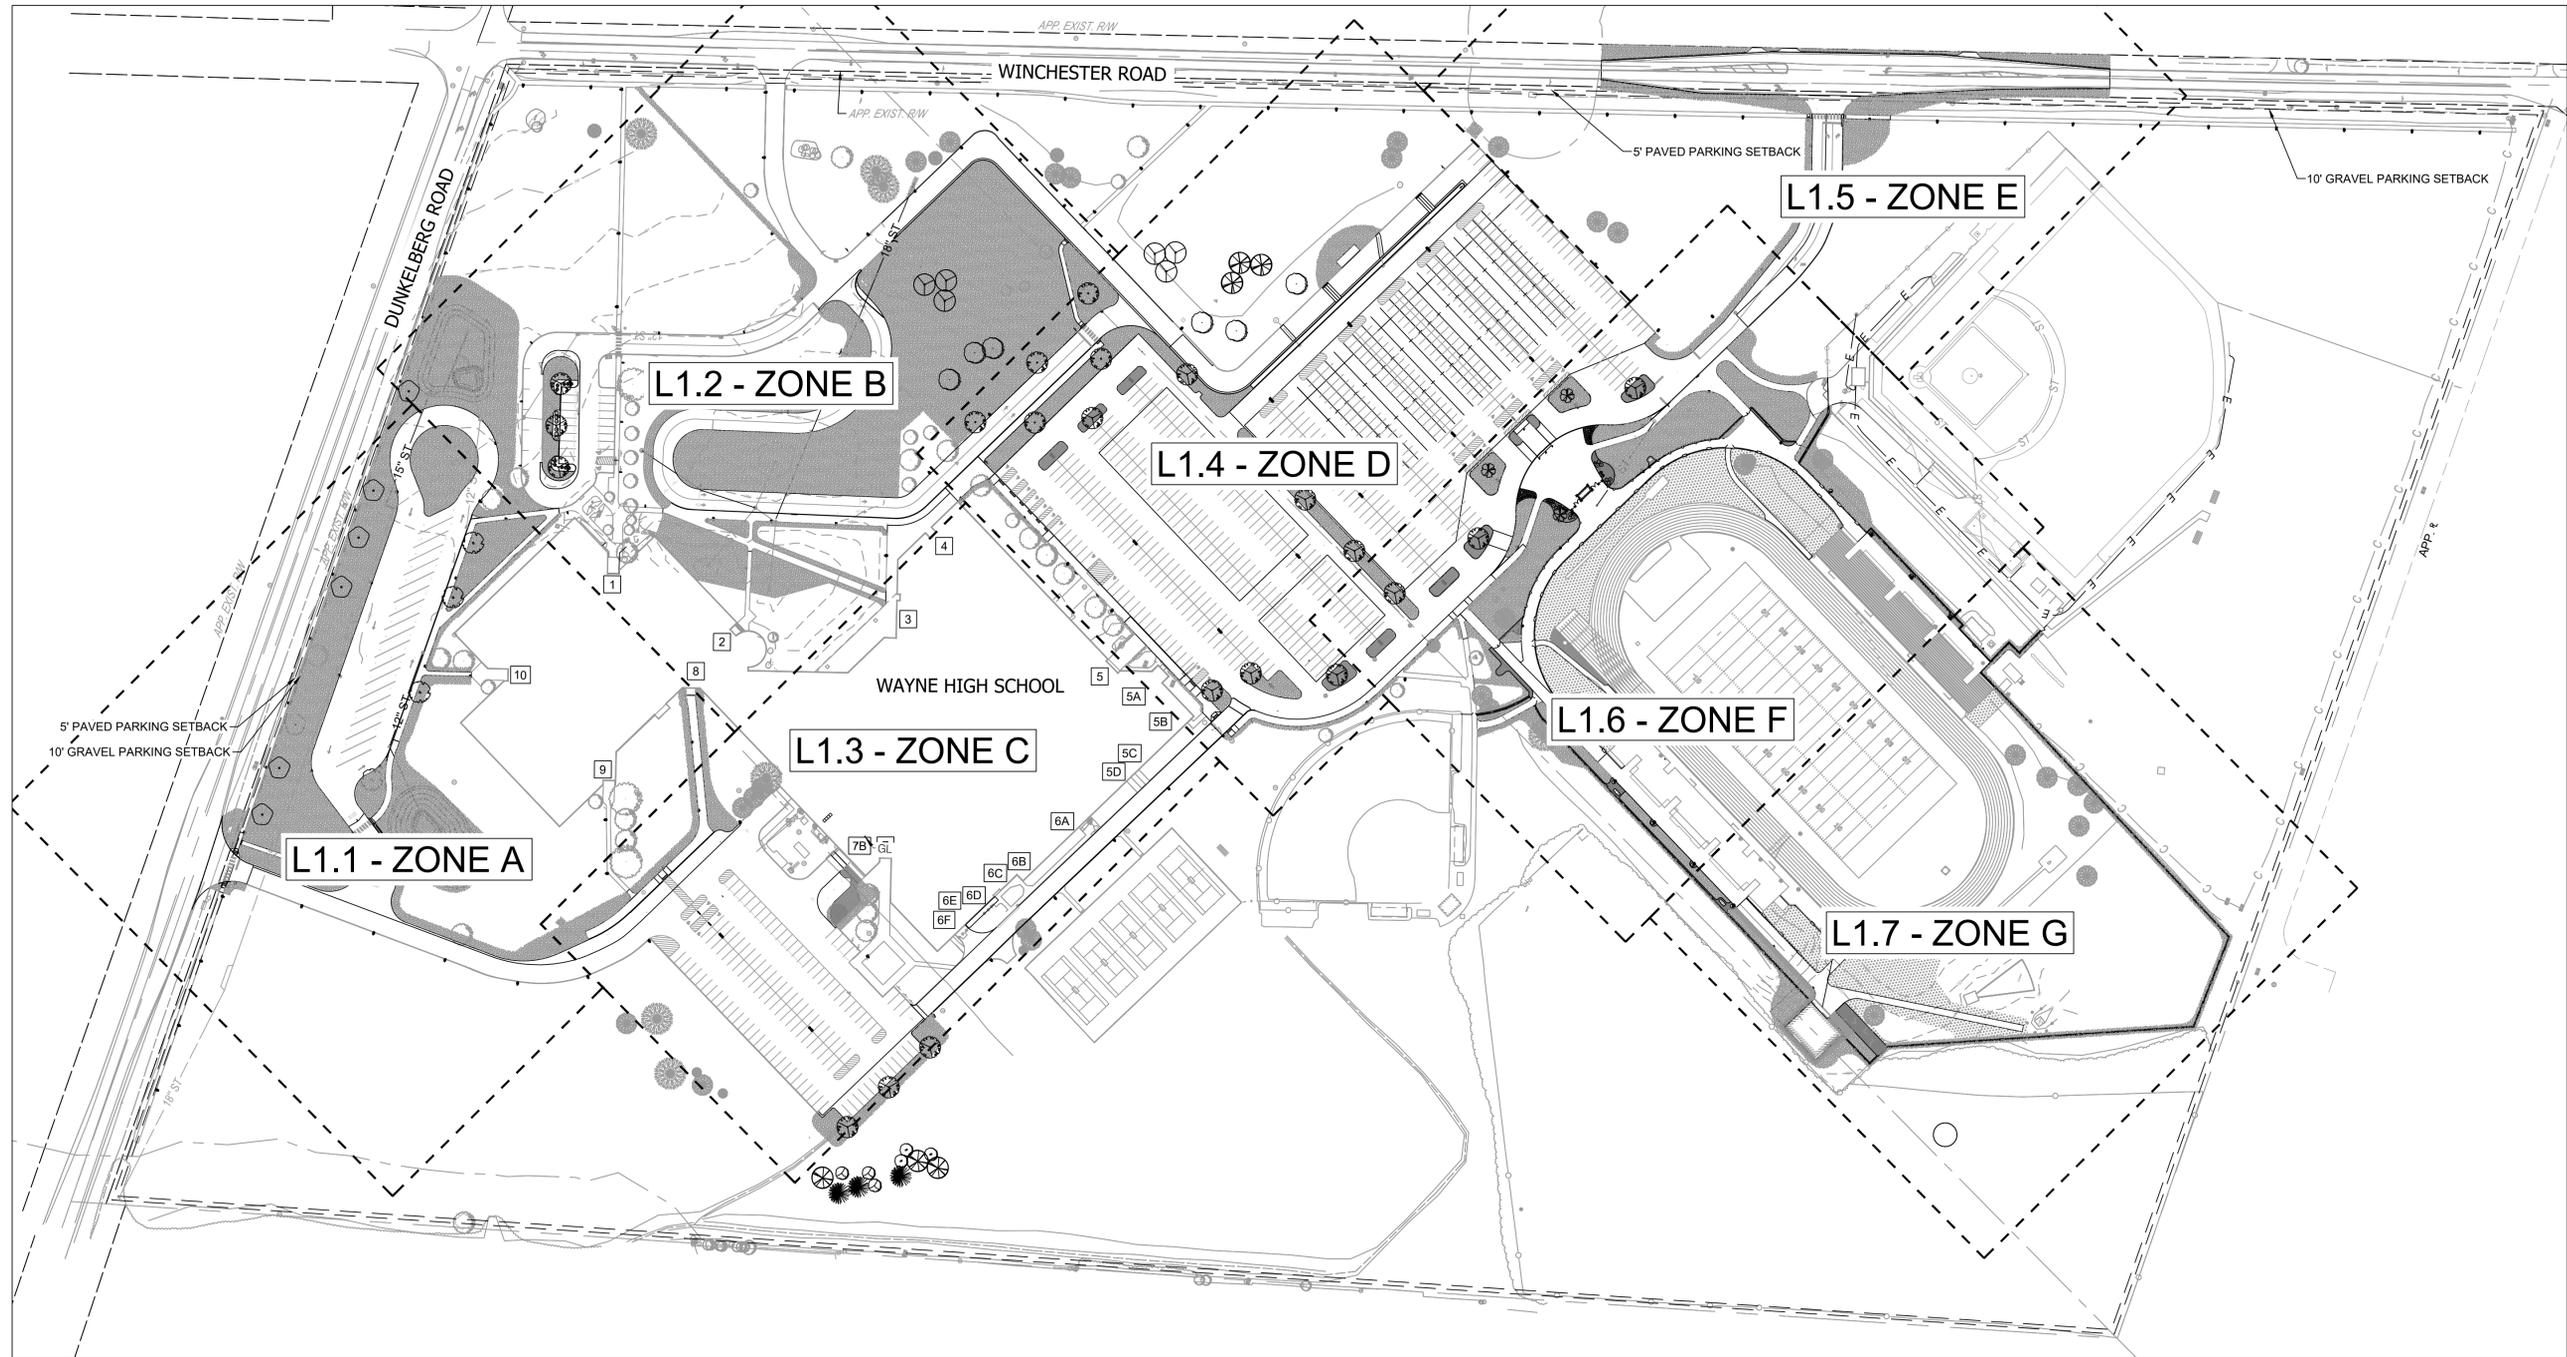

PLANT MATERIAL LIST

ID	BOTANICAL NAME	COMMON NAME	SIZE	QTY	ROOT
DECIDUOUS AND ORNAMENTAL TREES					
AS	ACER SACCHARUM 'GREEN MOUNTAIN'	GREEN MOUNTAIN SUGAR MAPLE	2.5" CAL.	6	B&B
AF	ACER FREEMANII 'ARMSTRONG'	ARMSTRONG FREEMAN MAPLE	2.5" CAL.	4	B&B
LR	LIQUIDAMBAR STYRACIFLUA 'ROTUNDILOBA'	ROTUNDILOBA SWEETGUM	2.5" CAL.	6	B&B
GD	GYNOCLADUS DIOICUS	KENTUCKY COFFEE TREE	2.5" CAL.	7	B&B
TA	TILIA AMERICANA 'REDMOND'	REDMOND AMERICAN BASSWOOD	2.5" CAL.	5	B&B
UA	ULMUS AMERICANA 'PRINCETON'	PRINCETON AMERICAN ELM	2.5" CAL.	7	B&B
UV	ULMUS AMERICANA 'VALLEY FORGE'	VALLEY FORGE AMERICAN ELM	2.5" CAL.	8	B&B
EVERGREEN TREES					
JV	JUNIPERUS VIRGINIANA	EASTERN RED CEDAR	6' H MIN.	6	B&B
PA	PICEA ABIES	NORWAY SPRUCE	6' H MIN.	3	B&B
ORNAMENTAL TREES					
AL	AMELANCHIER LAEVIS	ALLEGHENY SERVICEBERRY	6' H MIN.	3	B&B MULTISTEMMED
CC	CERCIS CANADENSIS	EASTERN REDBUD	6' H MIN.	3	B&B MULTISTEMMED
SHRUBS					
CA	CORNUS ALBA 'BAILHALO'	IVORY HALO DOGWOOD	NO. 5, 30" H MIN.	6	CONT.
IG	ILEX GLABRA 'DENSATA'	DENSA HOLLY	NO. 5, 30" H MIN.	10	CONT.

PLANT MATERIAL NOTES


- ALL PLANT MATERIAL TO MEET AMERICAN STANDARDS FOR NURSERY STOCK, 2014 EDITION/ HORTIS THIRD 1076 CORNELL UNIVERSITY.
- PLANT CONTAINER SIZES ARE SHOWN AS GUIDELINES ONLY (MINIMUM HEIGHT AND SPREAD REQUIREMENTS RULE). PLANT HEIGHT AND SPREAD SPECIFICATIONS ARE MINIMUMS, ON CENTER (O.C.) SPECIFICATIONS ARE MAXIMUMS.

ALTERNATE #5 - PLANT MATERIAL LIST

ID	BOTANICAL NAME	COMMON NAME	SIZE	QTY	ROOT
ORNAMENTAL TREES					
AL	AMELANCHIER LAEVIS	ALLEGHENY SERVICEBERRY	6' H MIN.	1	B&B MULTISTEMMED
CV	CRATAEGUS VIRIDIS 'WINTER KING'	WINTER KING HAWTHORN	6' H MIN.	2	B&B
UA	ULMUS AMERICANA 'PRINCETON'	PRINCETON AMERICAN ELM	2.5" CAL.	2	B&B
SHRUBS					
CA	CORNUS ALBA 'BAILHALO'	IVORY HALO DOGWOOD	NO. 5, 30" H MIN.	12	CONT.
IG	ILEX GLABRA 'DENSATA'	DENSA HOLLY	NO. 5, 30" H MIN.	6	CONT.
PERENNIALS					
NR	NEPETA X RACEMOSA 'WALKERS LOW'	WALKERS LOW CATMINT	1 GAL.	8	CONT.
SH	SPOROBOLUS HETEROLEPIS	PRAIRIE DROPSEED	1 GAL.	50	CONT.


REV	DESCRIPTION	BY	DATE
5	REVISION 4 FOR ADDENDUM 6	JJB	11-18-2025

IMEG JR
 JONES
 PETRIE
 PRAFINSKI
 Landscape Architects
 1200 S CLINTON STREET
 FORT WAYNE, IN 46804
 P: 317.446.5045 F: 317.444.2911


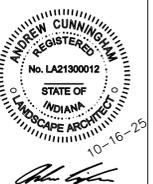


WAYNE HIGH SCHOOL CAMPUS IMPROVEMENTS
FORT WAYNE COMMUNITY SCHOOLS
 1200 S CLINTON STREET
SITE LANDSCAPE PLAN - OVERALL

DESIGNED BY: JJB
 REVIEWED BY: CEE, AC
 DRAWN BY: JJB
 REVIEWED BY: CEE, AC
 DATE: NOVEMBER 7, 2025
 JOB NUMBER: 2025-01487
 HORIZ. SCALE: 1" = 100'
 VERTICAL SCALE: N/A
L1.0

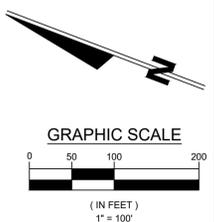

File: J:\Projects\2025\Projects\2025-01487 Wayne High School\07_Design\ENG\Plans\LC001_LANDSCAPE PLAN - OVERALL.dwg
 Saved By: bankley Plotted: 2025-11-18 10:11 AM

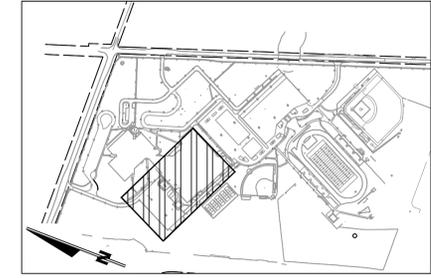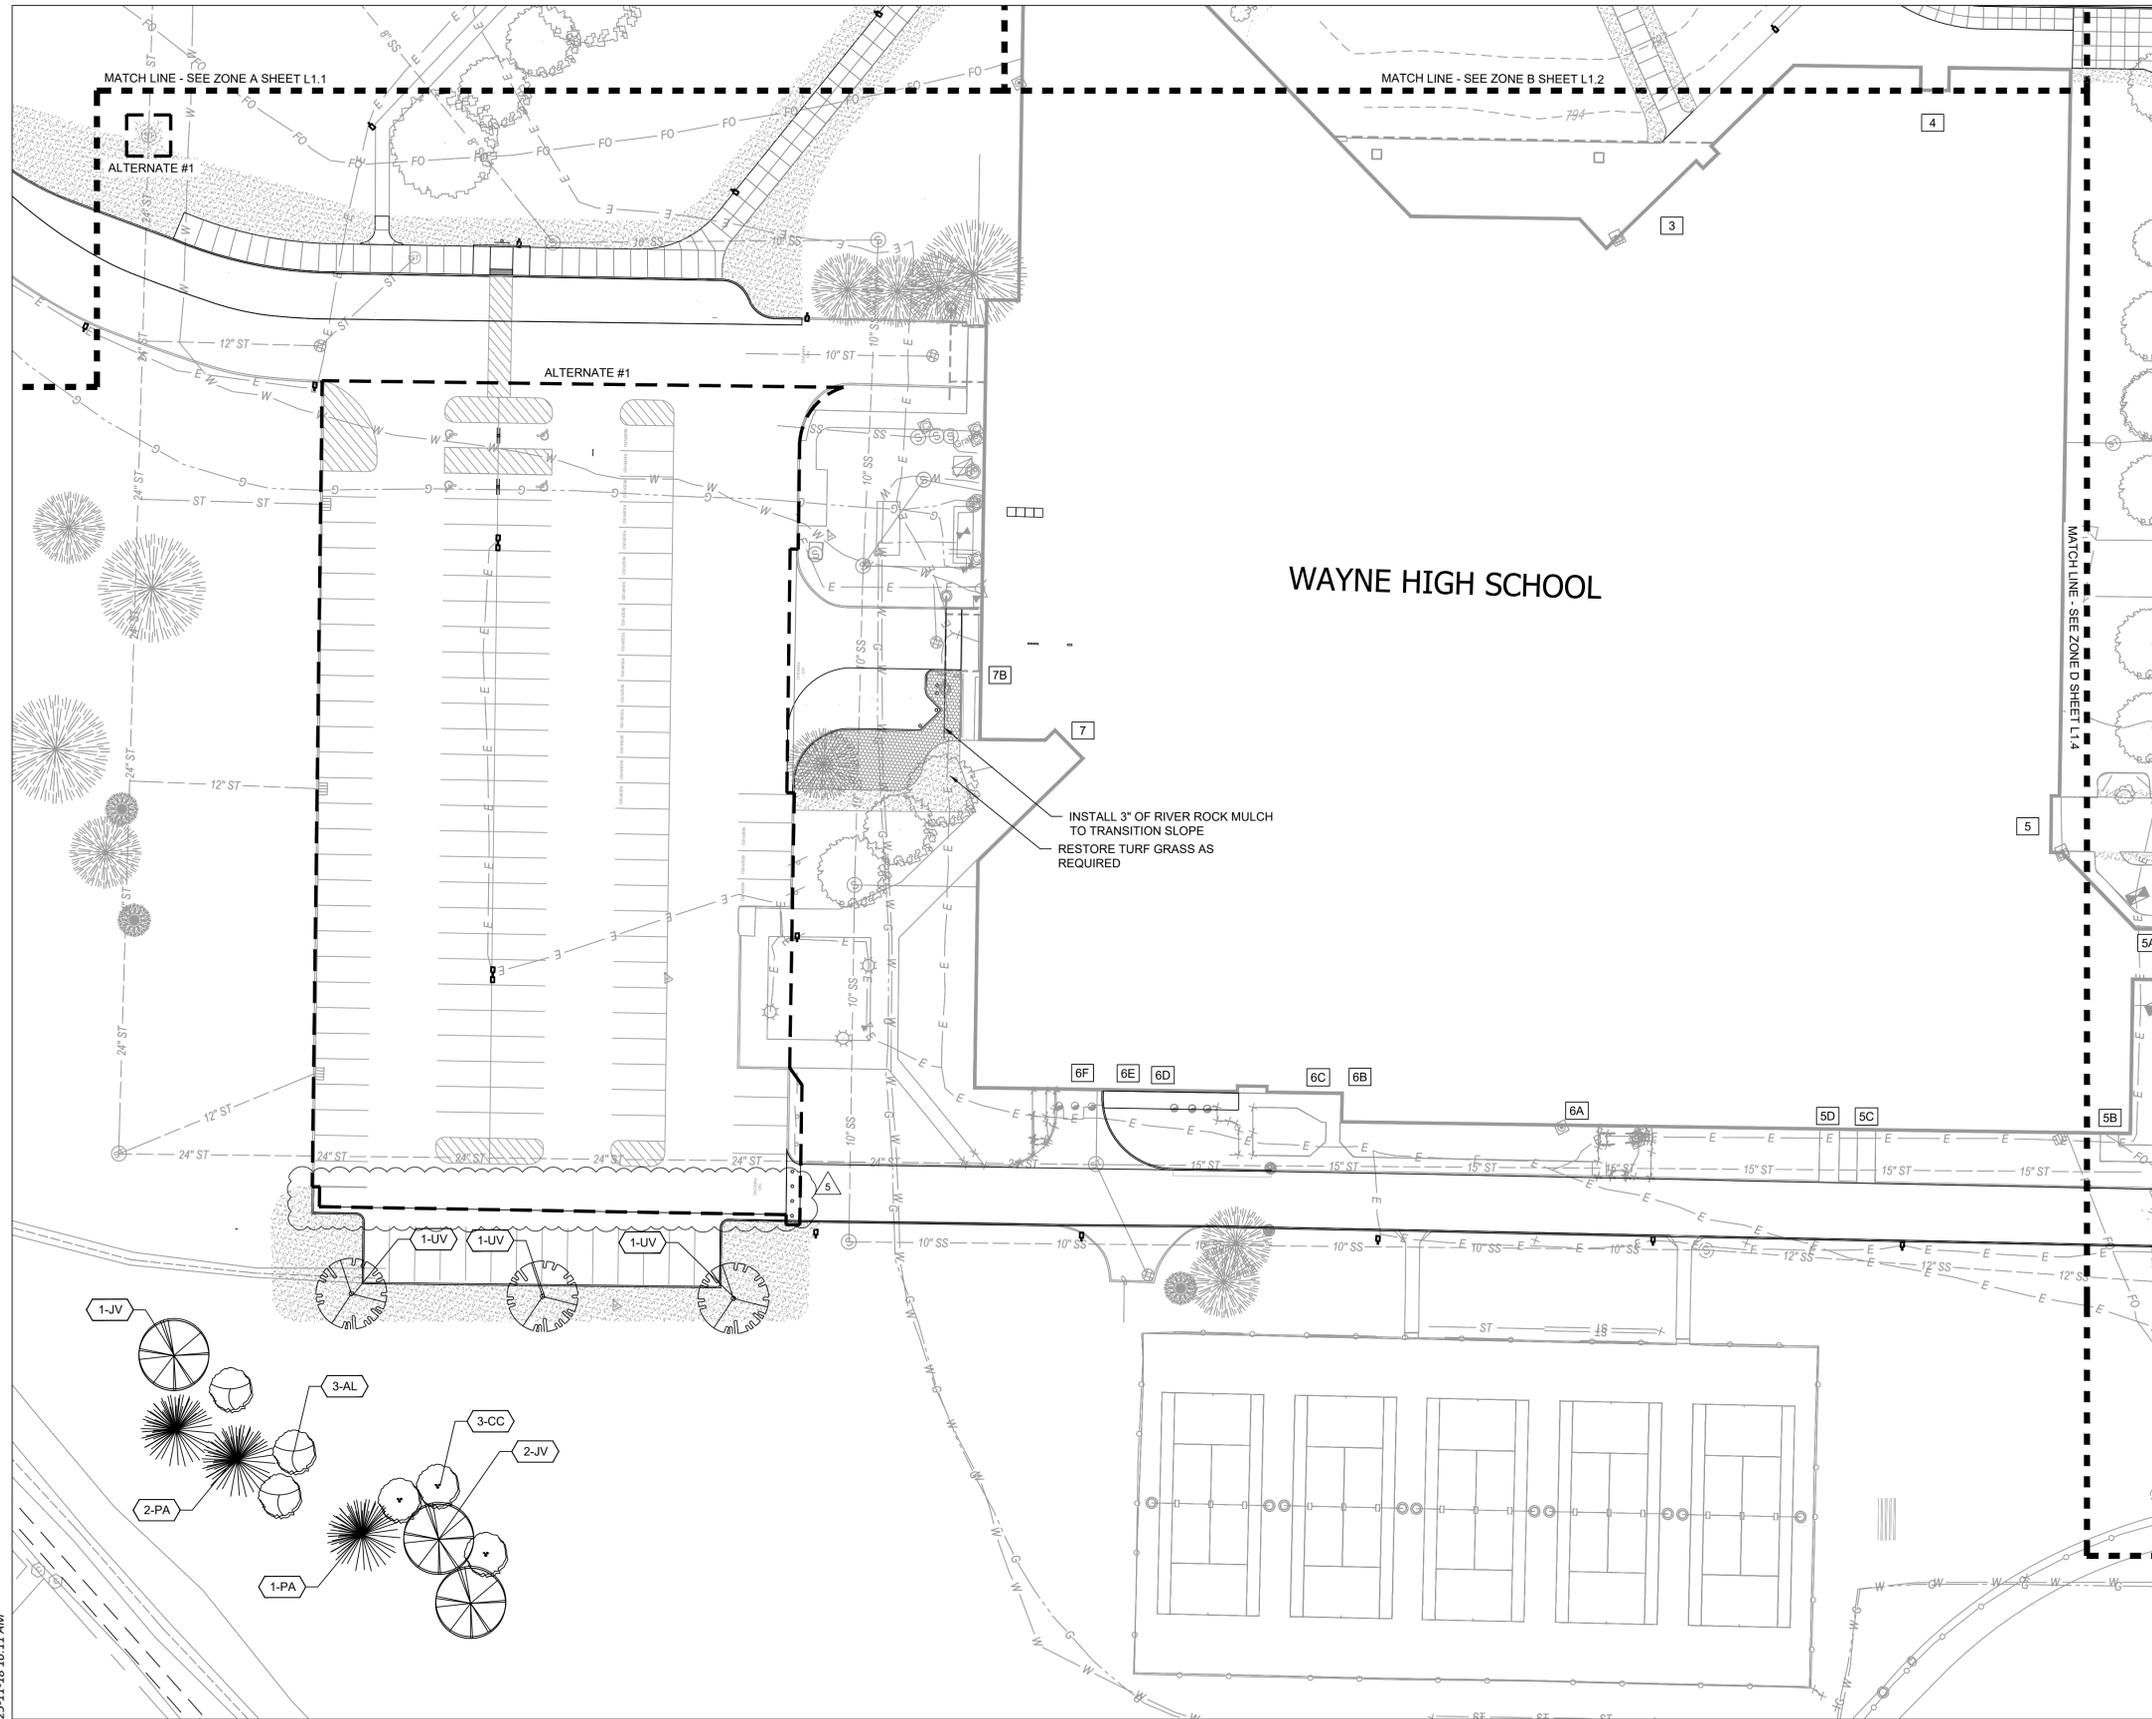


KEYNOTE PLAN - 1" = 600'

LEGEND

TURF GRASS SEEDING (SEE SEEDING NOTES ON SHEET L1.8)

ALTERNATES:

ALTERNATE #1: MILL AND RESURFACE STAFF PARKING LOT

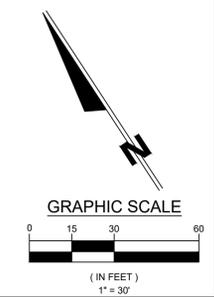

REV	DESCRIPTION	BY	DATE
5	REVISION 4 FOR ADDENDUM 6	JJB	11-18-2025

The contents, designs, plans, schedules and/or calculations shown on this document are the sole property of JPR and were created, developed, and presented for use on this specific project. Items are not to be used, copied, or reproduced in any form without the written consent or permission of JPR. © 2025 JPR. All rights reserved.

JONES P. PETRIE P. RAFFINSKI
 P.E. No. 14616, IN
 P. 874.232.4188
 P. 800.422.2629

IMEG JPR
 800 W. STATE ST., SUITE 210
 INDIANAPOLIS, IN 46204
 P. 317.646.9045 F. 317.644.2971



WAYNE HIGH SCHOOL CAMPUS IMPROVEMENTS
FORT WAYNE COMMUNITY SCHOOLS
 1200 S CLINTON STREET
SITE LANDSCAPE PLAN - ZONE C

DESIGNED BY: JJB
 REVIEWED BY: CEE, AC

DRAWN BY: JJB
 REVIEWED BY: CEE, AC



DATE: NOVEMBER 7, 2025

JOB NUMBER: 2025-01487

HORIZ. SCALE: 1" = 30'
 VERTICAL SCALE: N/A

L1.3

File: J:\Projects\2025\Projects\2025-01487 Wayne High School\07_Design\ENG\Plans\1001_LANDSCAPE PLAN - OVERALL.dwg
 Saved By: jankley Plotted: 2025-11-18 10:15 AM

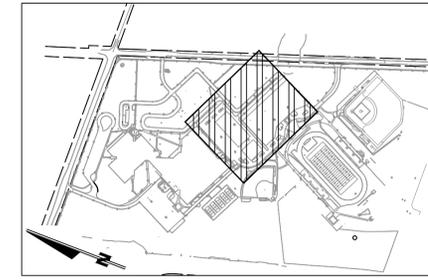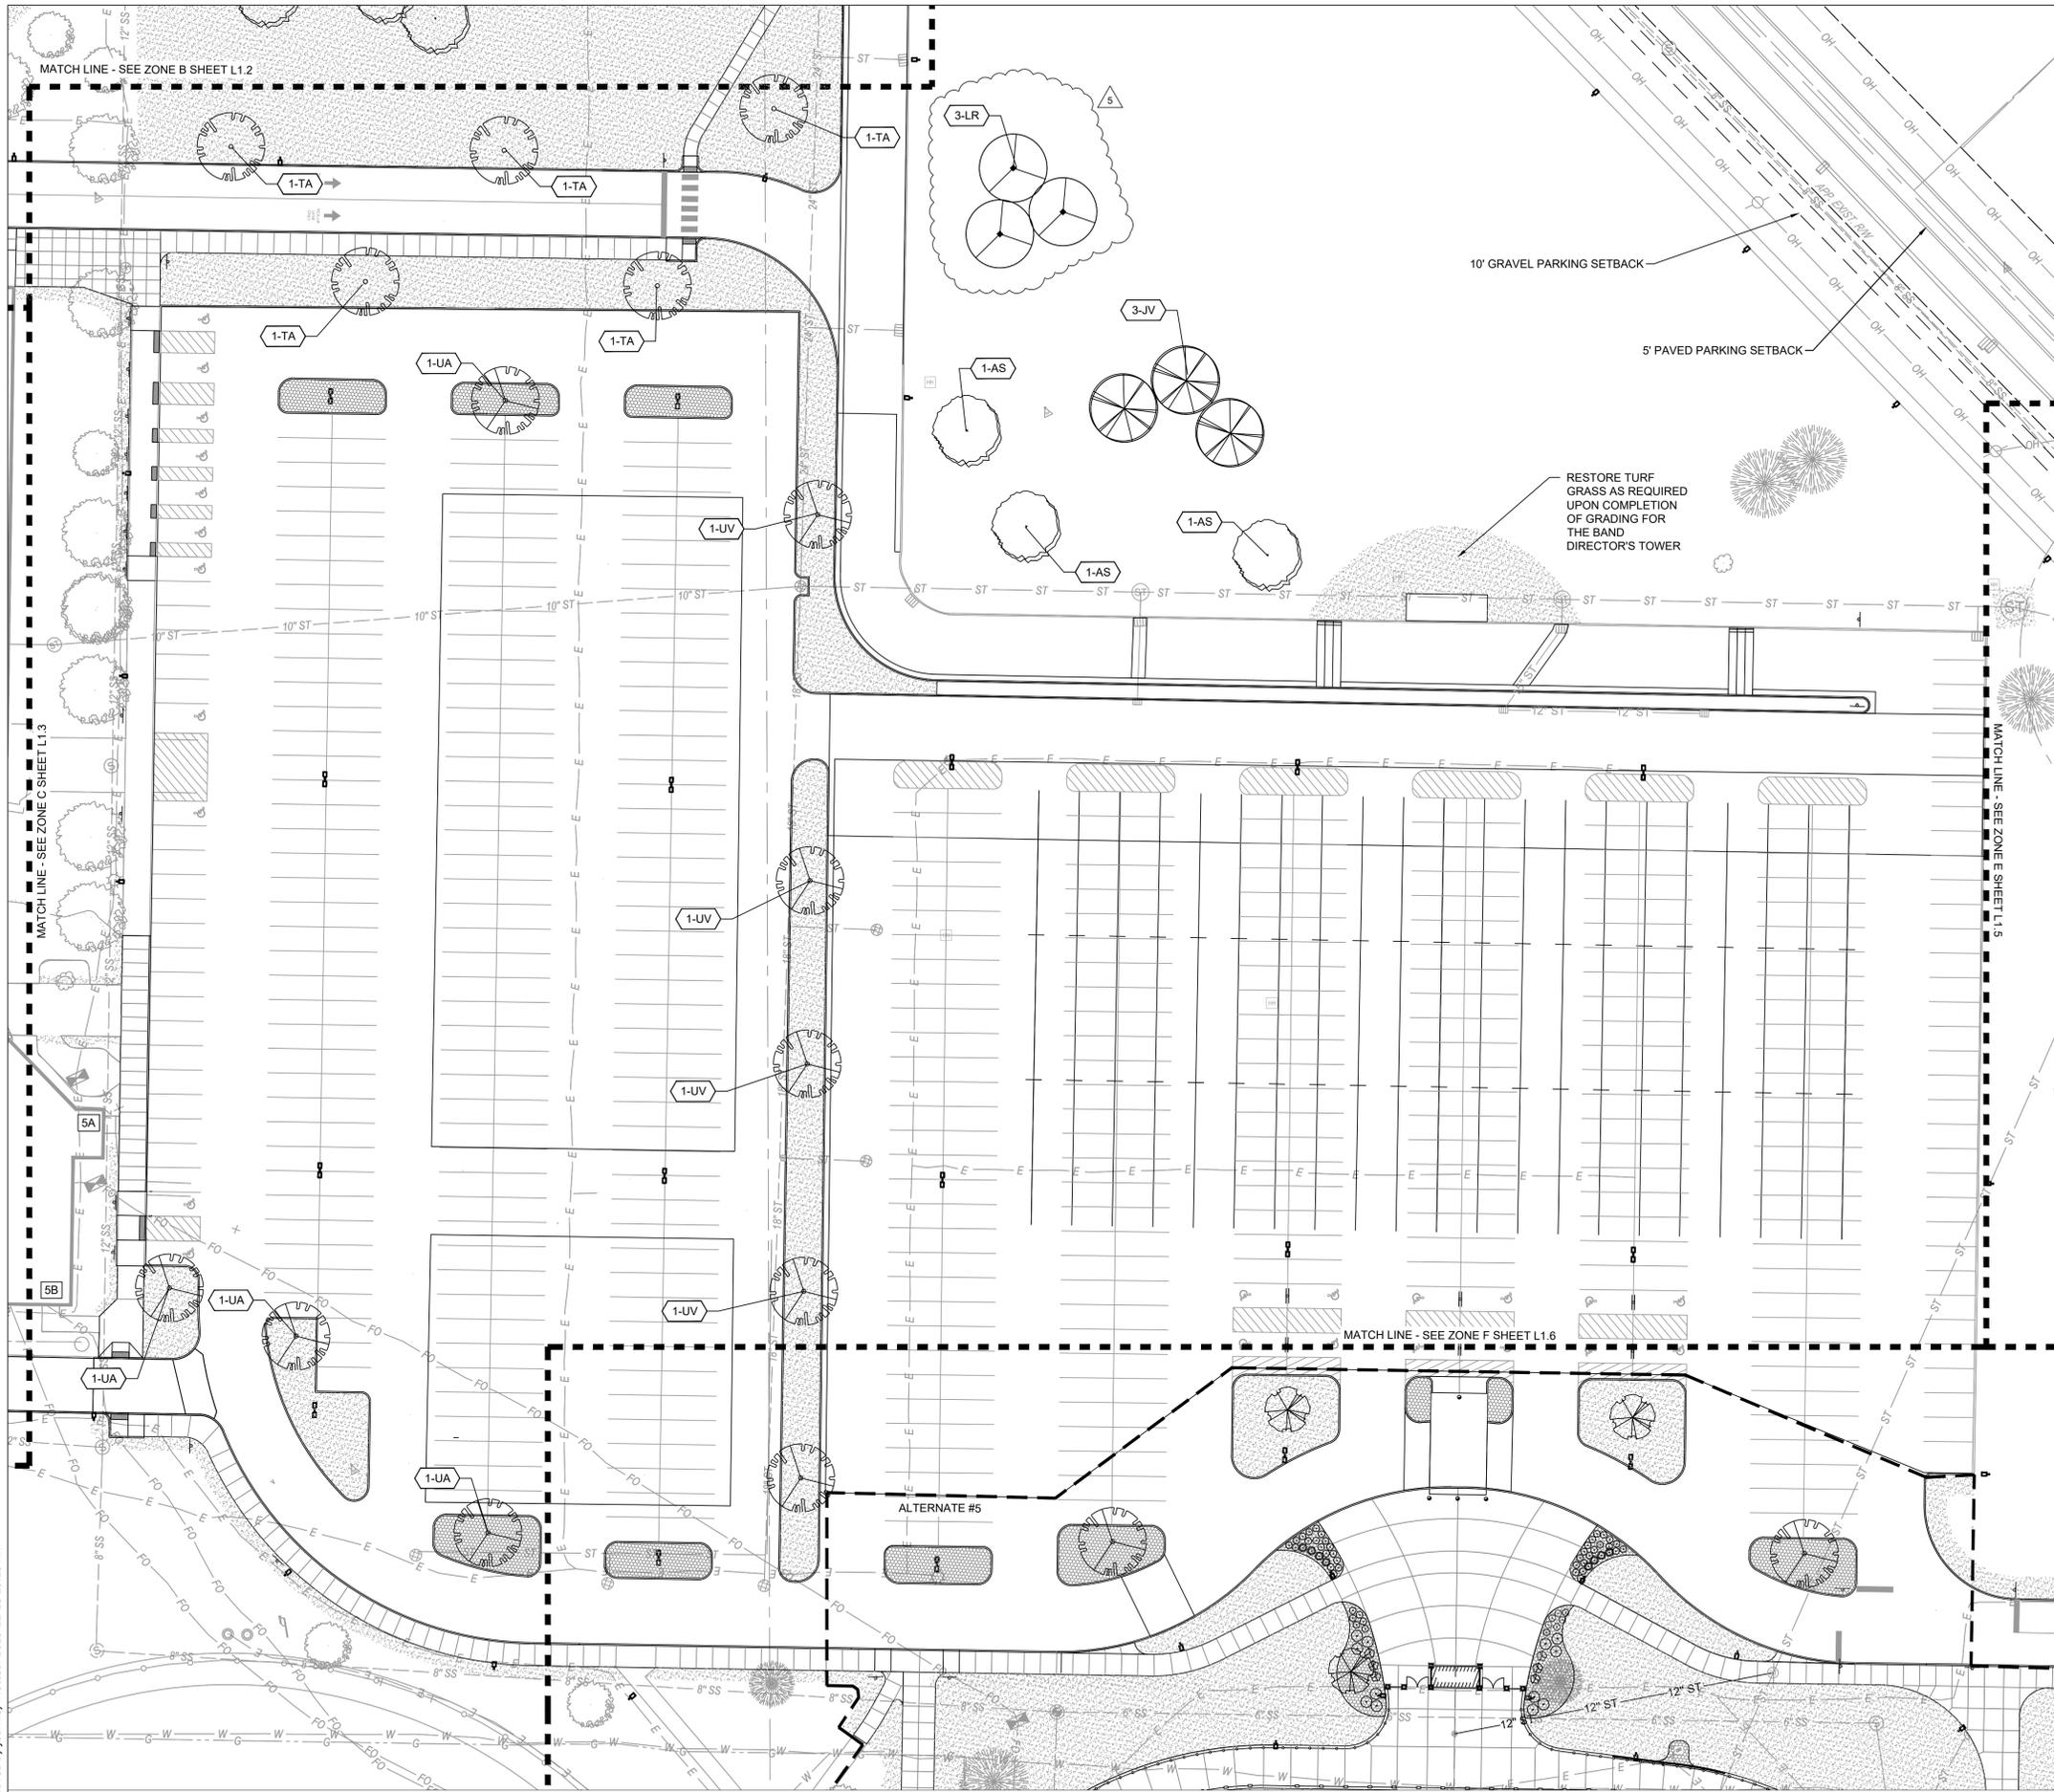


- LEGEND**
- TURF GRASS SEED (SEE SEEDING NOTES ON SHEET L1.8)
 - AGGREGATE MULCH (SEE NOTES ON SHEET L1.8)
 - RIVERROCK MULCH (SEE NOTES ON SHEET L1.8)

REV	DESCRIPTION	BY	DATE
5	REVISION 4 FOR ADDENDUM 6	JB	11-18-2025

The contents, designs, plans, schedules, etc. are the property of J.P.R. and were created, developed, and presented for use on this specific project. Items are not to be used, copied, or reproduced without the express written permission of J.P.R. © 2025 J.P.R. All Rights Reserved.

JONES PETRIE PRAFRANSKI
 ARCHITECTS
 100 N. W. 10th St., Suite 210
 Ft. Wayne, IN 46804
 P: 317.444.2971 F: 317.444.2971

IMEG JR
 REGISTERED PROFESSIONAL ENGINEER
 100 N. W. 10th St., Suite 210
 Ft. Wayne, IN 46804
 P: 317.444.2971 F: 317.444.2971

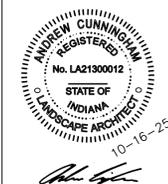

WAYNE HIGH SCHOOL CAMPUS IMPROVEMENTS
FORT WAYNE COMMUNITY SCHOOLS
 1200 S CLINTON STREET
SITE LANDSCAPE PLAN - ZONE D

DESIGNED BY: JB
 REVIEWED BY: CEE, AC

DRAWN BY: JB
 REVIEWED BY: CEE, AC

DATE: NOVEMBER 7, 2025

JOB NUMBER: 2025-01487

HORIZ. SCALE: 1" = 30'
 VERTICAL SCALE: N/A

L1.4

